


05 Sep 2017 - 11:16g MAT Wall Enterprises LLC\140245_Wingra Point Phase 2\CADD\140245_base_eng.dwg by:amec

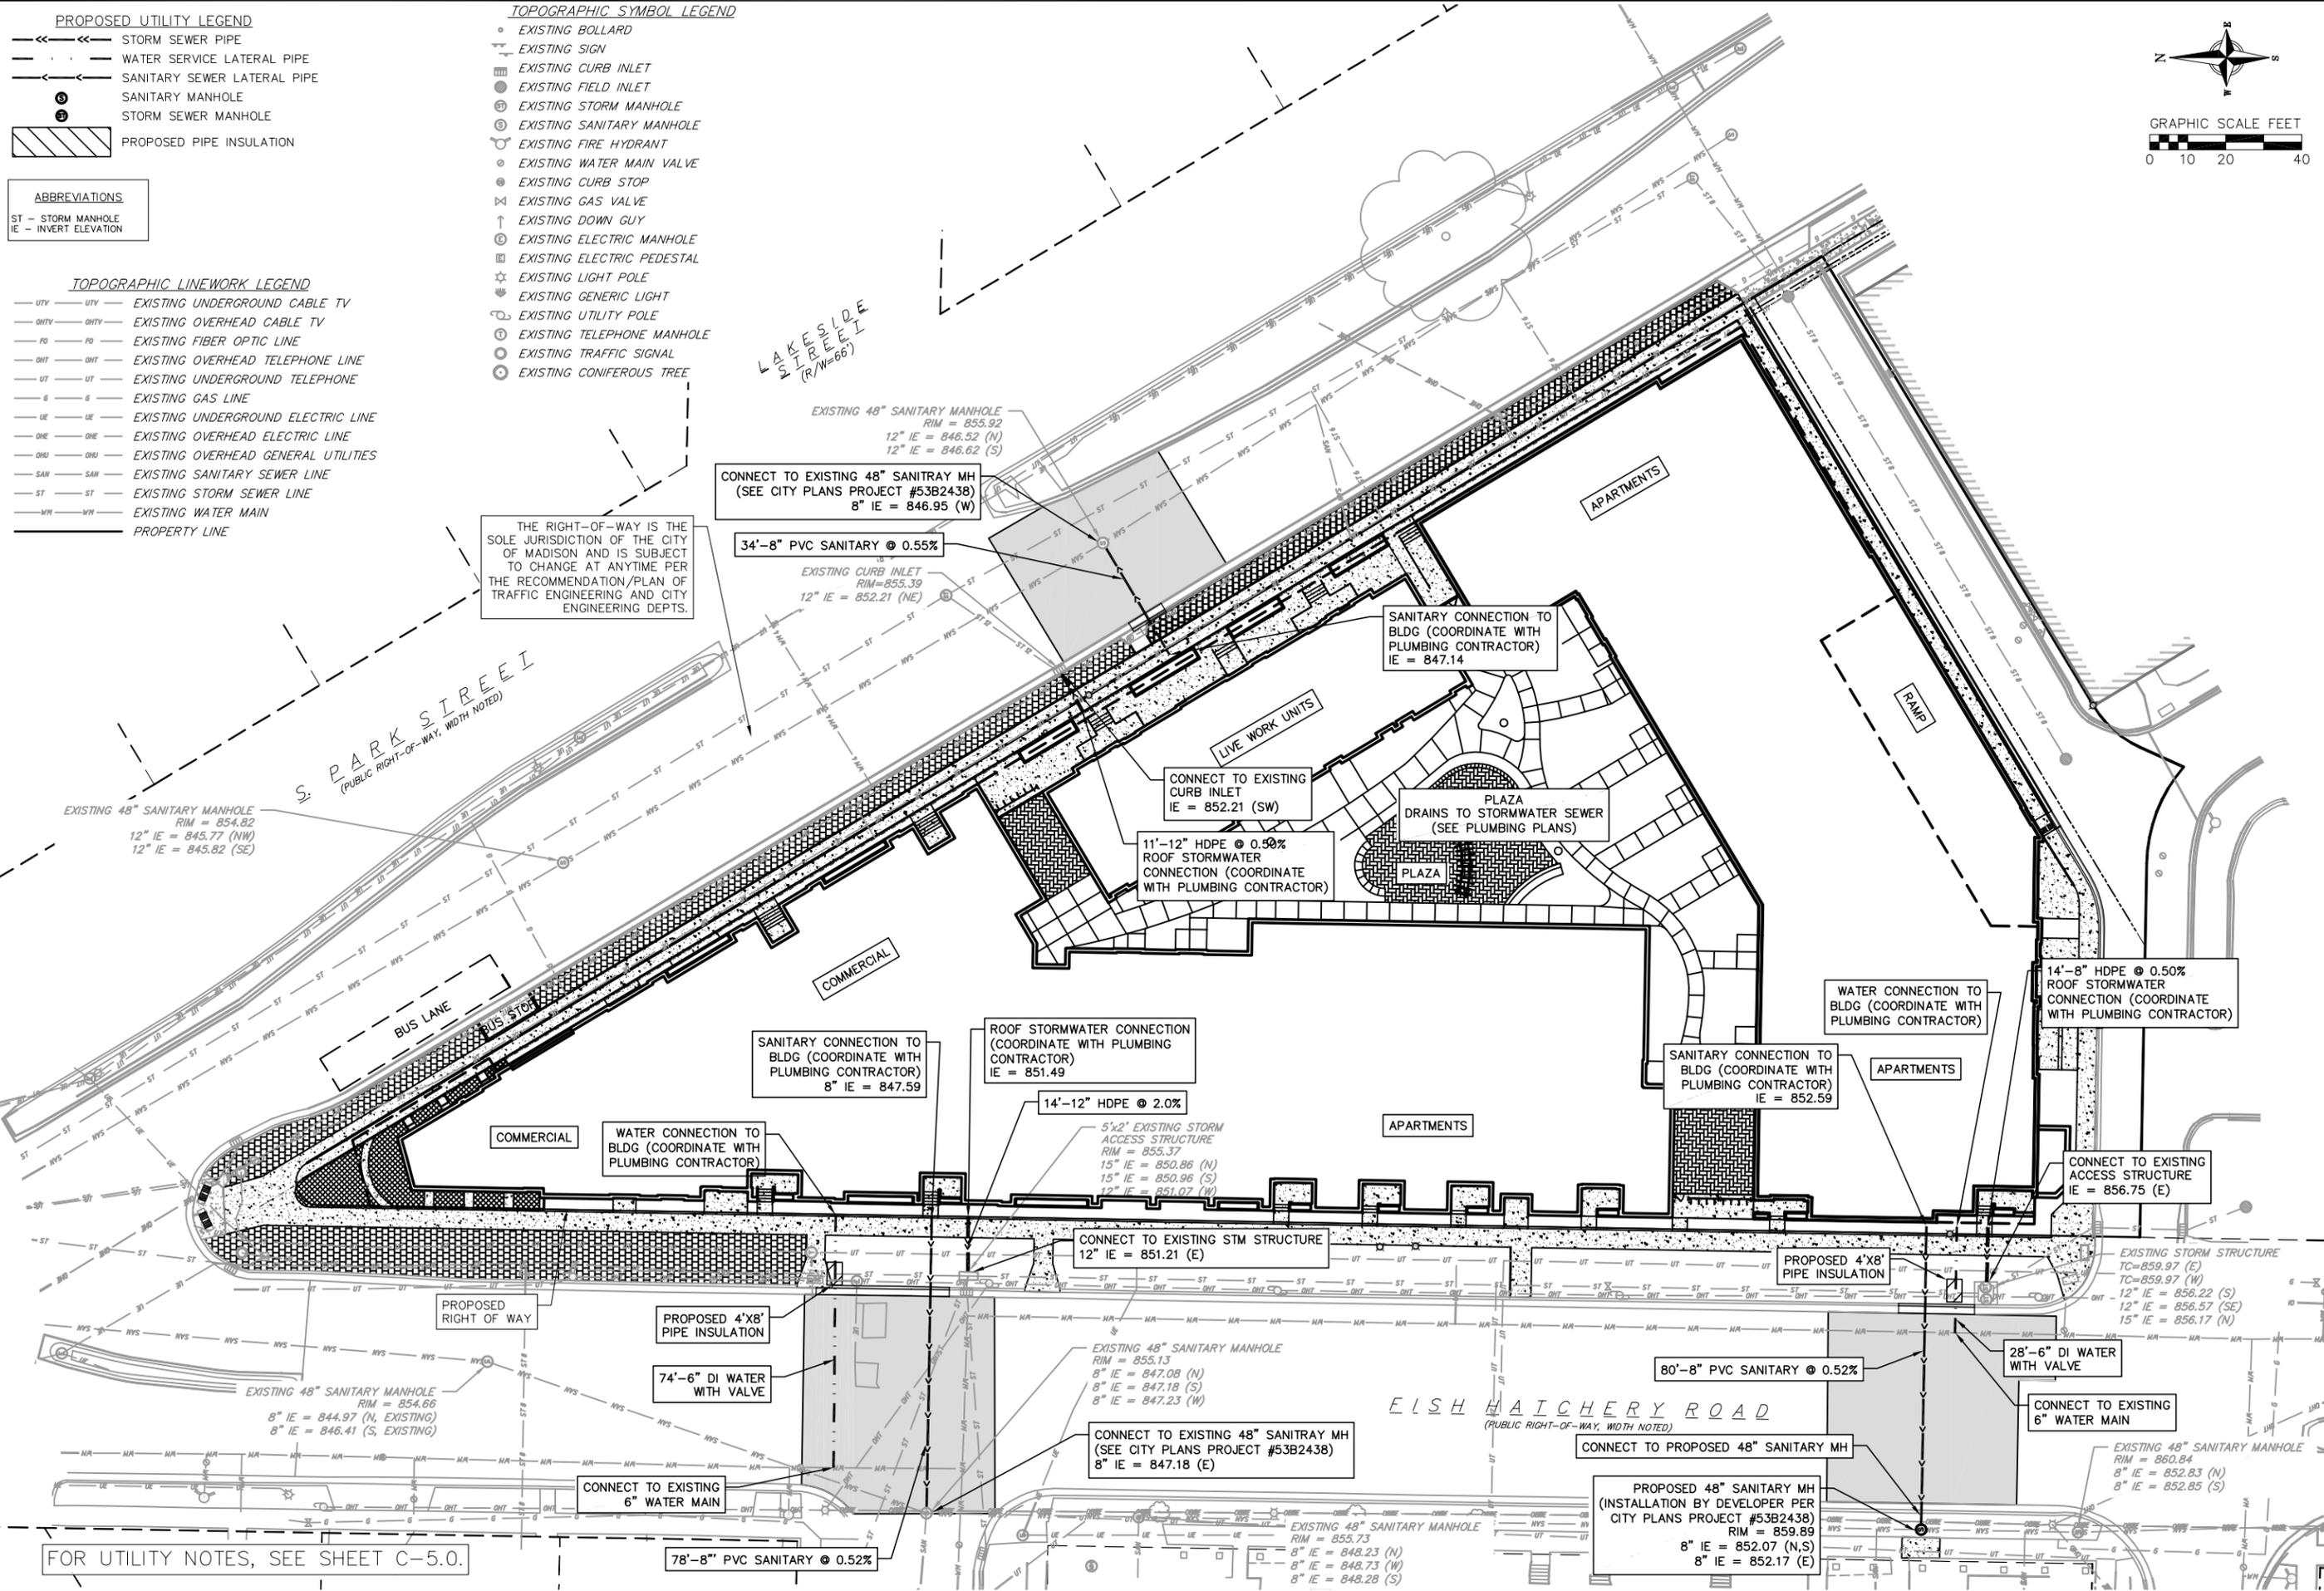


- PROPOSED UTILITY LEGEND**
- STORM SEWER PIPE
 - WATER SERVICE LATERAL PIPE
 - SANITARY SEWER LATERAL PIPE
 - SANITARY MANHOLE
 - STORM SEWER MANHOLE
 - PROPOSED PIPE INSULATION

ABBREVIATIONS

ST - STORM MANHOLE
IE - INVERT ELEVATION

- TOPOGRAPHIC LINEWORK LEGEND**
- UTV - EXISTING UNDERGROUND CABLE TV
 - OHV - EXISTING OVERHEAD CABLE TV
 - FO - EXISTING FIBER OPTIC LINE
 - OHT - EXISTING OVERHEAD TELEPHONE LINE
 - UT - EXISTING UNDERGROUND TELEPHONE
 - G - EXISTING GAS LINE
 - UE - EXISTING UNDERGROUND ELECTRIC LINE
 - OHE - EXISTING OVERHEAD ELECTRIC LINE
 - OHW - EXISTING OVERHEAD GENERAL UTILITIES
 - SAW - EXISTING SANITARY SEWER LINE
 - ST - EXISTING STORM SEWER LINE
 - WM - EXISTING WATER MAIN
 - PROPERTY LINE

- TOPOGRAPHIC SYMBOL LEGEND**
- EXISTING BOLLARD
 - EXISTING SIGN
 - EXISTING CURB INLET
 - EXISTING FIELD INLET
 - EXISTING STORM MANHOLE
 - EXISTING SANITARY MANHOLE
 - EXISTING FIRE HYDRANT
 - EXISTING WATER MAIN VALVE
 - EXISTING CURB STOP
 - EXISTING GAS VALVE
 - EXISTING DOWN GUY
 - EXISTING ELECTRIC MANHOLE
 - EXISTING ELECTRIC PEDESTAL
 - EXISTING LIGHT POLE
 - EXISTING GENERIC LIGHT
 - EXISTING UTILITY POLE
 - EXISTING TELEPHONE MANHOLE
 - EXISTING TRAFFIC SIGNAL
 - EXISTING CONIFEROUS TREE

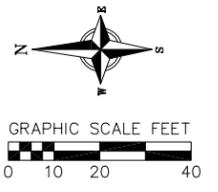

vierbicher
planners | engineers | advisors
REEDSBURG - MADISON - PRAIRIE DU CHIEN
999 Prairie du Chien
Phone: (608) 824-0332 Fax: (608) 824-0330

Utility Plan
Pelaton Residences
City of Madison
Dane County, Wisconsin

NO.	DATE	REVISIONS	REMARKS

SCALE AS SHOWN

DATE 09/06/2017
DRAFTER AMEA
CHECKED RKOL
PROJECT NO. 140245
SHEET 4 OF 6
DWG. NO. C-4.0

FOR UTILITY NOTES, SEE SHEET C-5.0.